


Notes:-

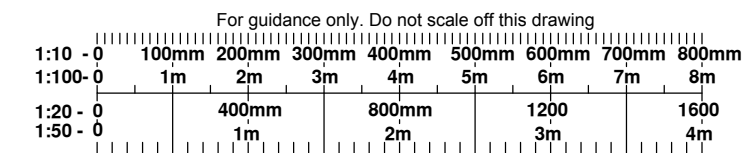

Do not scale from this drawing

Site layout based on architects drawing 17_3407_34 (July 2019).

This drawing is for planning purposes only, and does not constitute construction level information. All details are subject to planning approval and Severn Trent Water consent. No construction to be undertaken until the required approvals are obtained in writing from the relevant authorities.

Foul water from the site will be discharge from the site via a private pumping station, with a final connection into the public foul/combined drainage network. Pump Station to be designed by specialist designer.

- Key
- Proposed Surface Water Manhole
 - Proposed Surface Water Drain/Sewer
 - Proposed Surface Water Rising Main Route
 - Existing Public Surface Water Sewer Manhole (approximate position)
 - Proposed Foul Water Manhole
 - Proposed Foul Water Drain/Sewer
 - Proposed Foul Water Rising Main Route
 - Existing Public Foul Sewer Manhole (approximate position)

REV.	DATE	AMENDMENT	BY
CLIENT			

Lychgate Homes

PROJECT

Proposed Development at

Burton Road, Rosliston

DRAWING TITLE

Proposed Foul Water

Drainage Layout


SCALE 1:200 SHEET SIZE A1

MICHAEL EVANS
& ASSOCIATES LTD.

Consulting Civil & Structural Engineers

34 Station Road, Draycott, Derbyshire DE72 3QB
Tel. 01332 871840 Fax. 01332 871841

DRAWN	ND	DRAWING NO.	Rev.
DATE	Sept 19	19-351-002	-

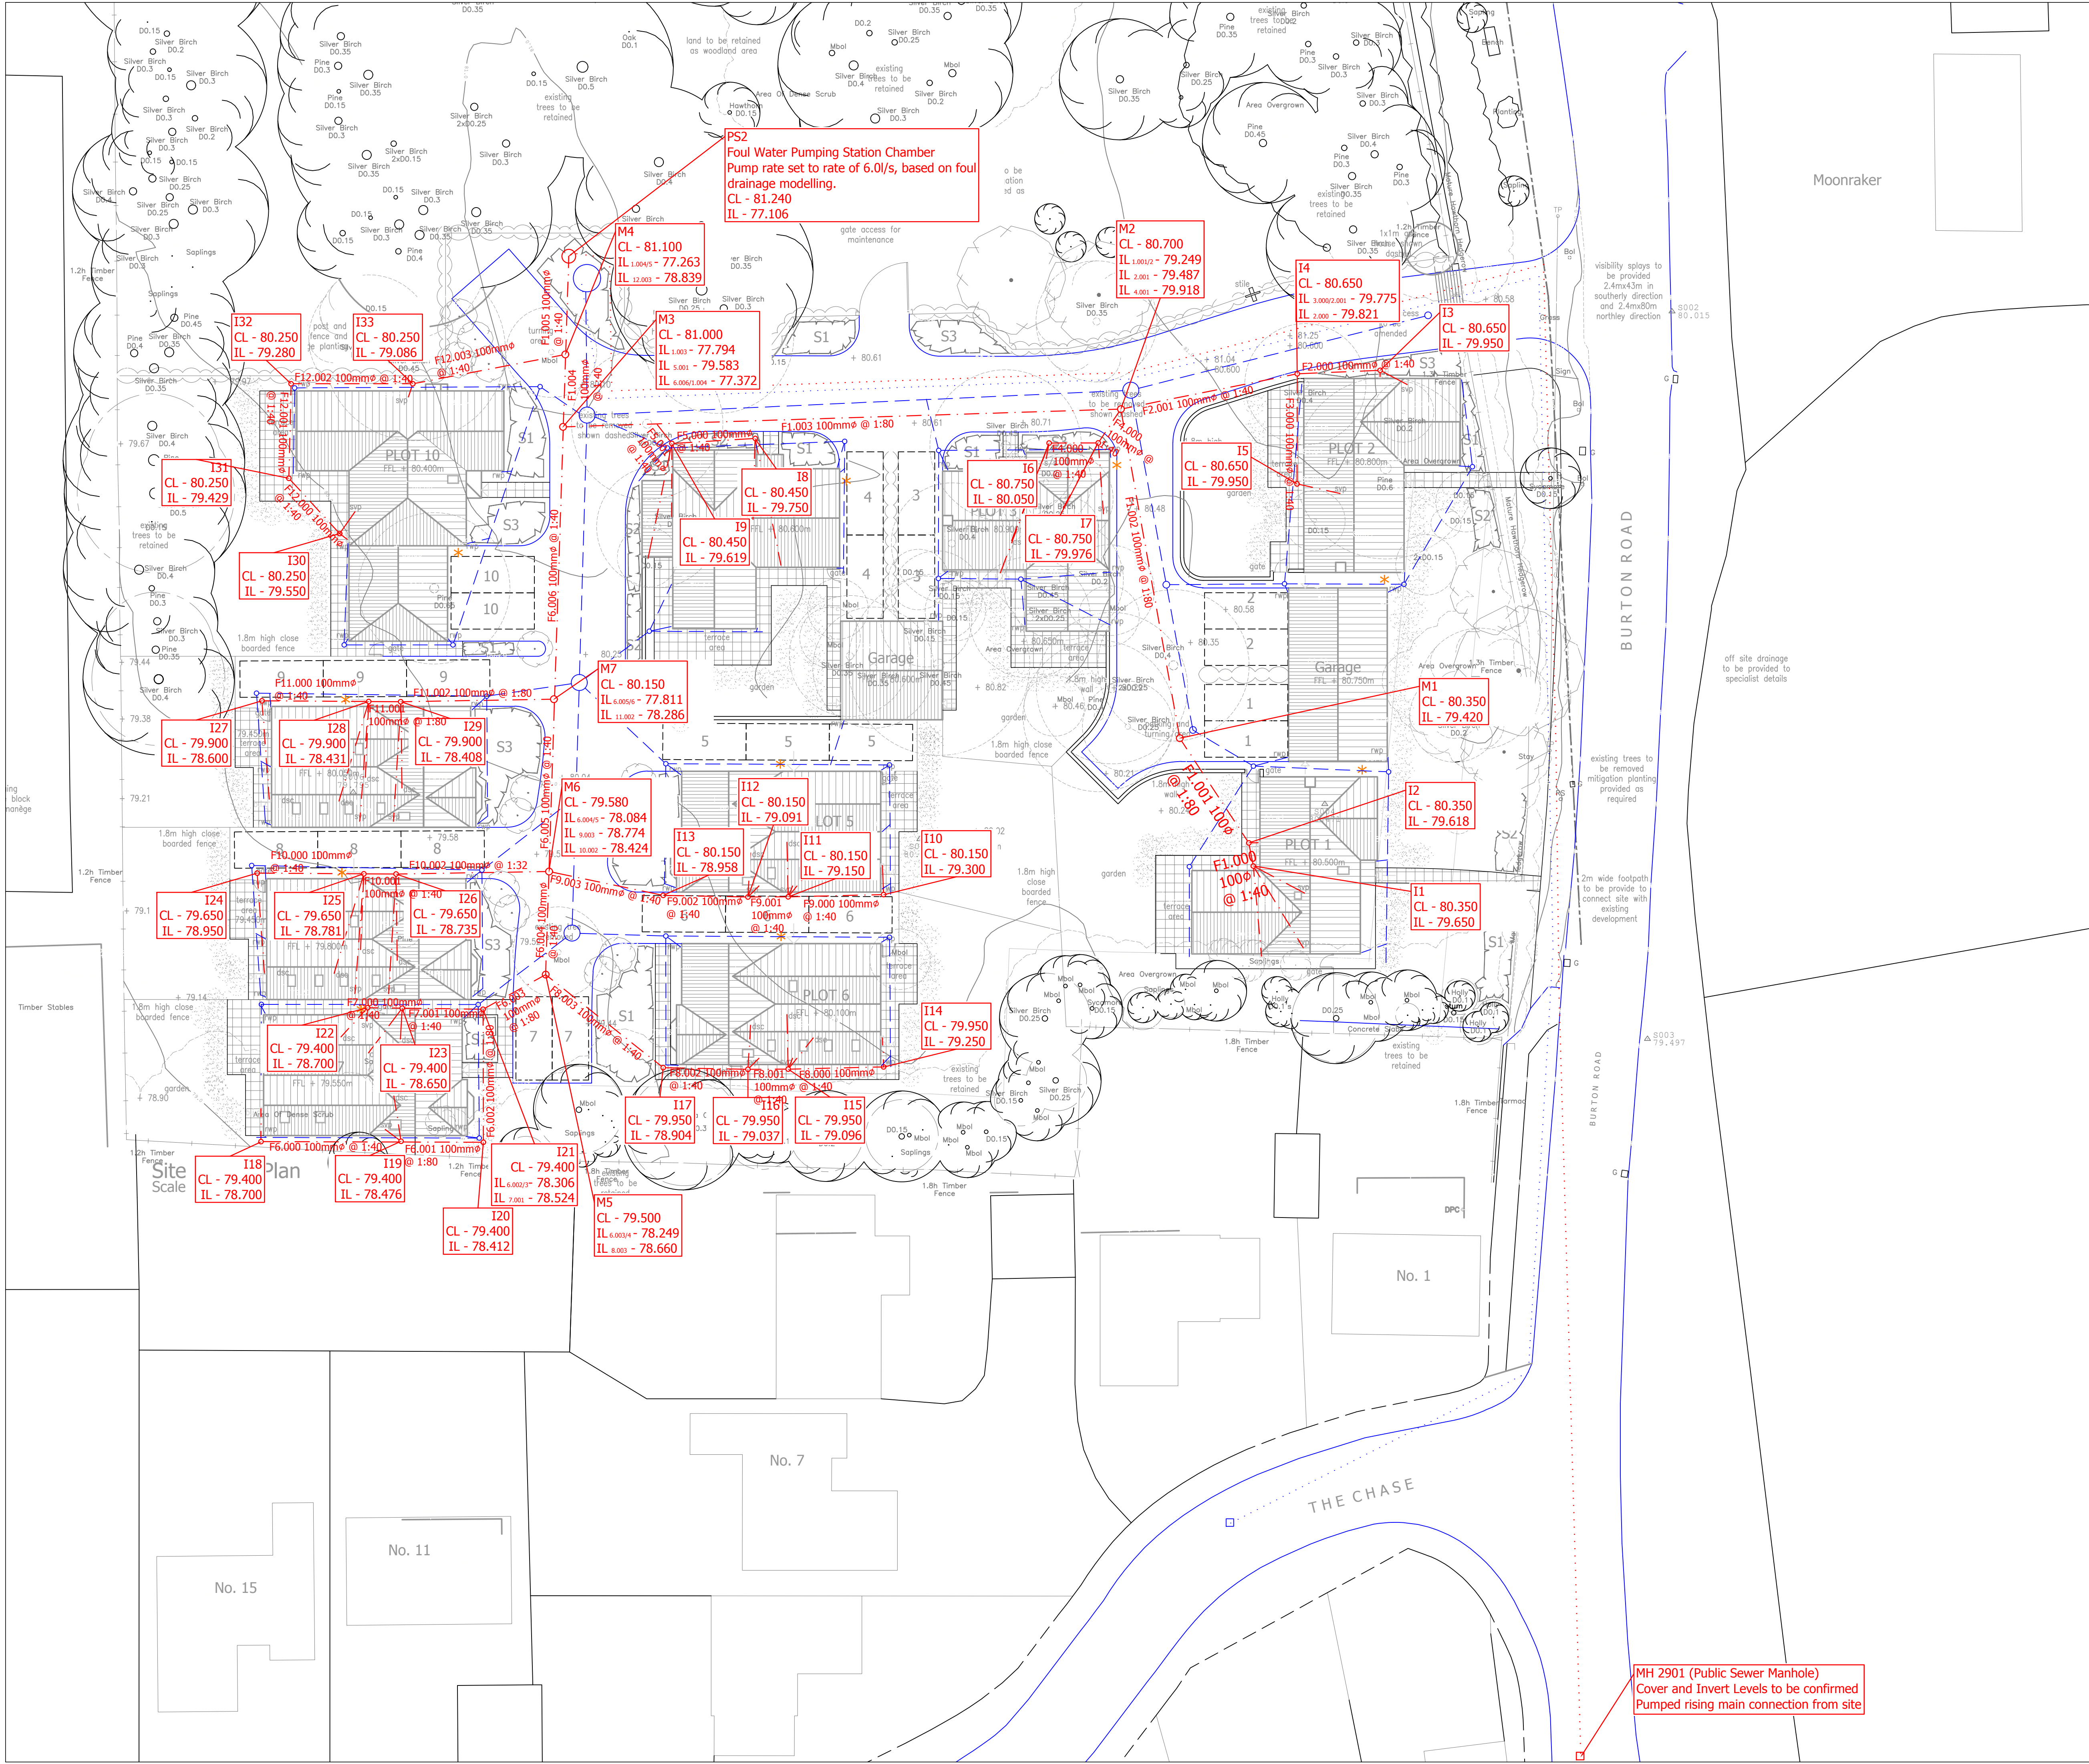

MH 2901 (Public Sewer Manhole)
Cover and Invert Levels to be confirmed
Pumped rising main connection from site