

EXISTING EXIT
CROSSING

STORAGE

SALES SHOP

TRANSFORMER
UNIT

PSU UNIT

ELECTROLYSER UNIT

PC9 UNIT

SWITCH
GEAR CABINET

BUFFER
TANK

HYDRO
SWITCHROOM

ELECTRIC BOARD
MAINTENANCE BAY

EXISTING
ID SIGN

AIR / WATER

CHARGE BAY

AIR / WATER

H2 DISPENSER

CANOPY OVER

GENERAL FORECOURT

Ex. Canopy Over

6 5
MPP

4 3
MPP

2 1
MPP


12 11
MPP

10 9
MPP

8 7
MPP


GENERAL NOTES

- THIS DRAWING HAS BEEN PREPARED FOR CONSTRUCTION PURPOSES ONLY
- DO NOT SCALE OFF THIS DRAWING
- THIS DRAWING IS TO BE READ IN CONJUNCTION WITH THE FOLLOWING ALONG WITH ALL OTHER SPECIALIST DRAWINGS:
 - ITM details and specifications
 - Structural Engineers details and specifications
 - Malcolm Hughes Land Surveyors Topo and Underground Services drawing no. 52408/UG1 - September 2018
 - Jennings Design Details:
 - DERBY 10957168 - EXTG-10 2021 - Existing Site Plan
 - DERBY 10957168 - GSP-11 2021 - General Site Plan
 - DERBY 10957168 - CBP-12 2021 - Compound Base Plan
 - DERBY 10957168 - CSP-13 2021 - Compound Services Plan
 - DERBY 10957168 - CED-14 2021 - Compound Elevations & Details
 - DERBY 10957168 - SOP-15-1 2021 - Setting Out Plan (Sheet 1)
 - DERBY 10957168 - SOP-15-2 2021 - Setting Out Plan (Sheet 2)
 - DERBY 10957168 - TRCK-16 2021 - Tracking Layout
 - DERBY 10957168 - CL17 2021 - Canopy Layout

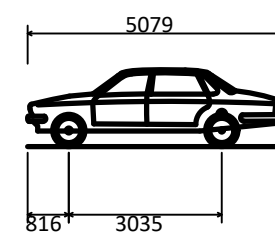

Large Car (2006)
Overall Length 5079mm
Overall Width 1872mm
Overall Body Height 1525mm
Min Body Ground Clearance 310mm
Max Track Width 1831mm
Lock to Lock Time 4.00 sec
Kerb to Kerb Turning Radius 5900mm

5M LARGE CAR

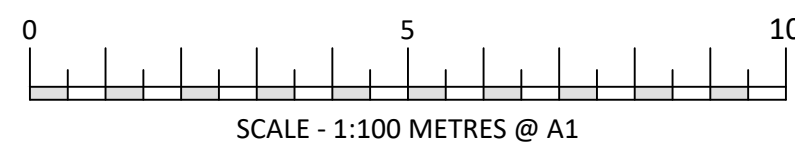

tank ve

REV	DATE	BY
CONSTRUCTION		
JENNINGS DESIGN LIMITED		
York House, Valley Court Canal Road, Bradford West Yorkshire BD1 4SP		
TEL. No 01274 395422 FAX. No 01274 395427 E-mail office@jen305.com		
PROJECT : SHELL DERBY ETWALL ROAD DERBYSHIRE DE65 6DX		
TITLE : H2 - TRACKING LAYOUT		
 SHELL UK LIMITED SHELL CENTRE LONDON SE1 7NA UNITED KINGDOM		
DRAWN BY :	WW	SCALE : 1:100 @ A1
DATE :	23/07/2021	PLOT DATE : 23/07/2021
CAD FILE :	E:\ARCHIVE\DRAWINGS\DERBY-10957168-CONST-21	
DWG No :	10957168	TRCK-16
	21	-

A1

ORIGINAL
PLOT SIZE