


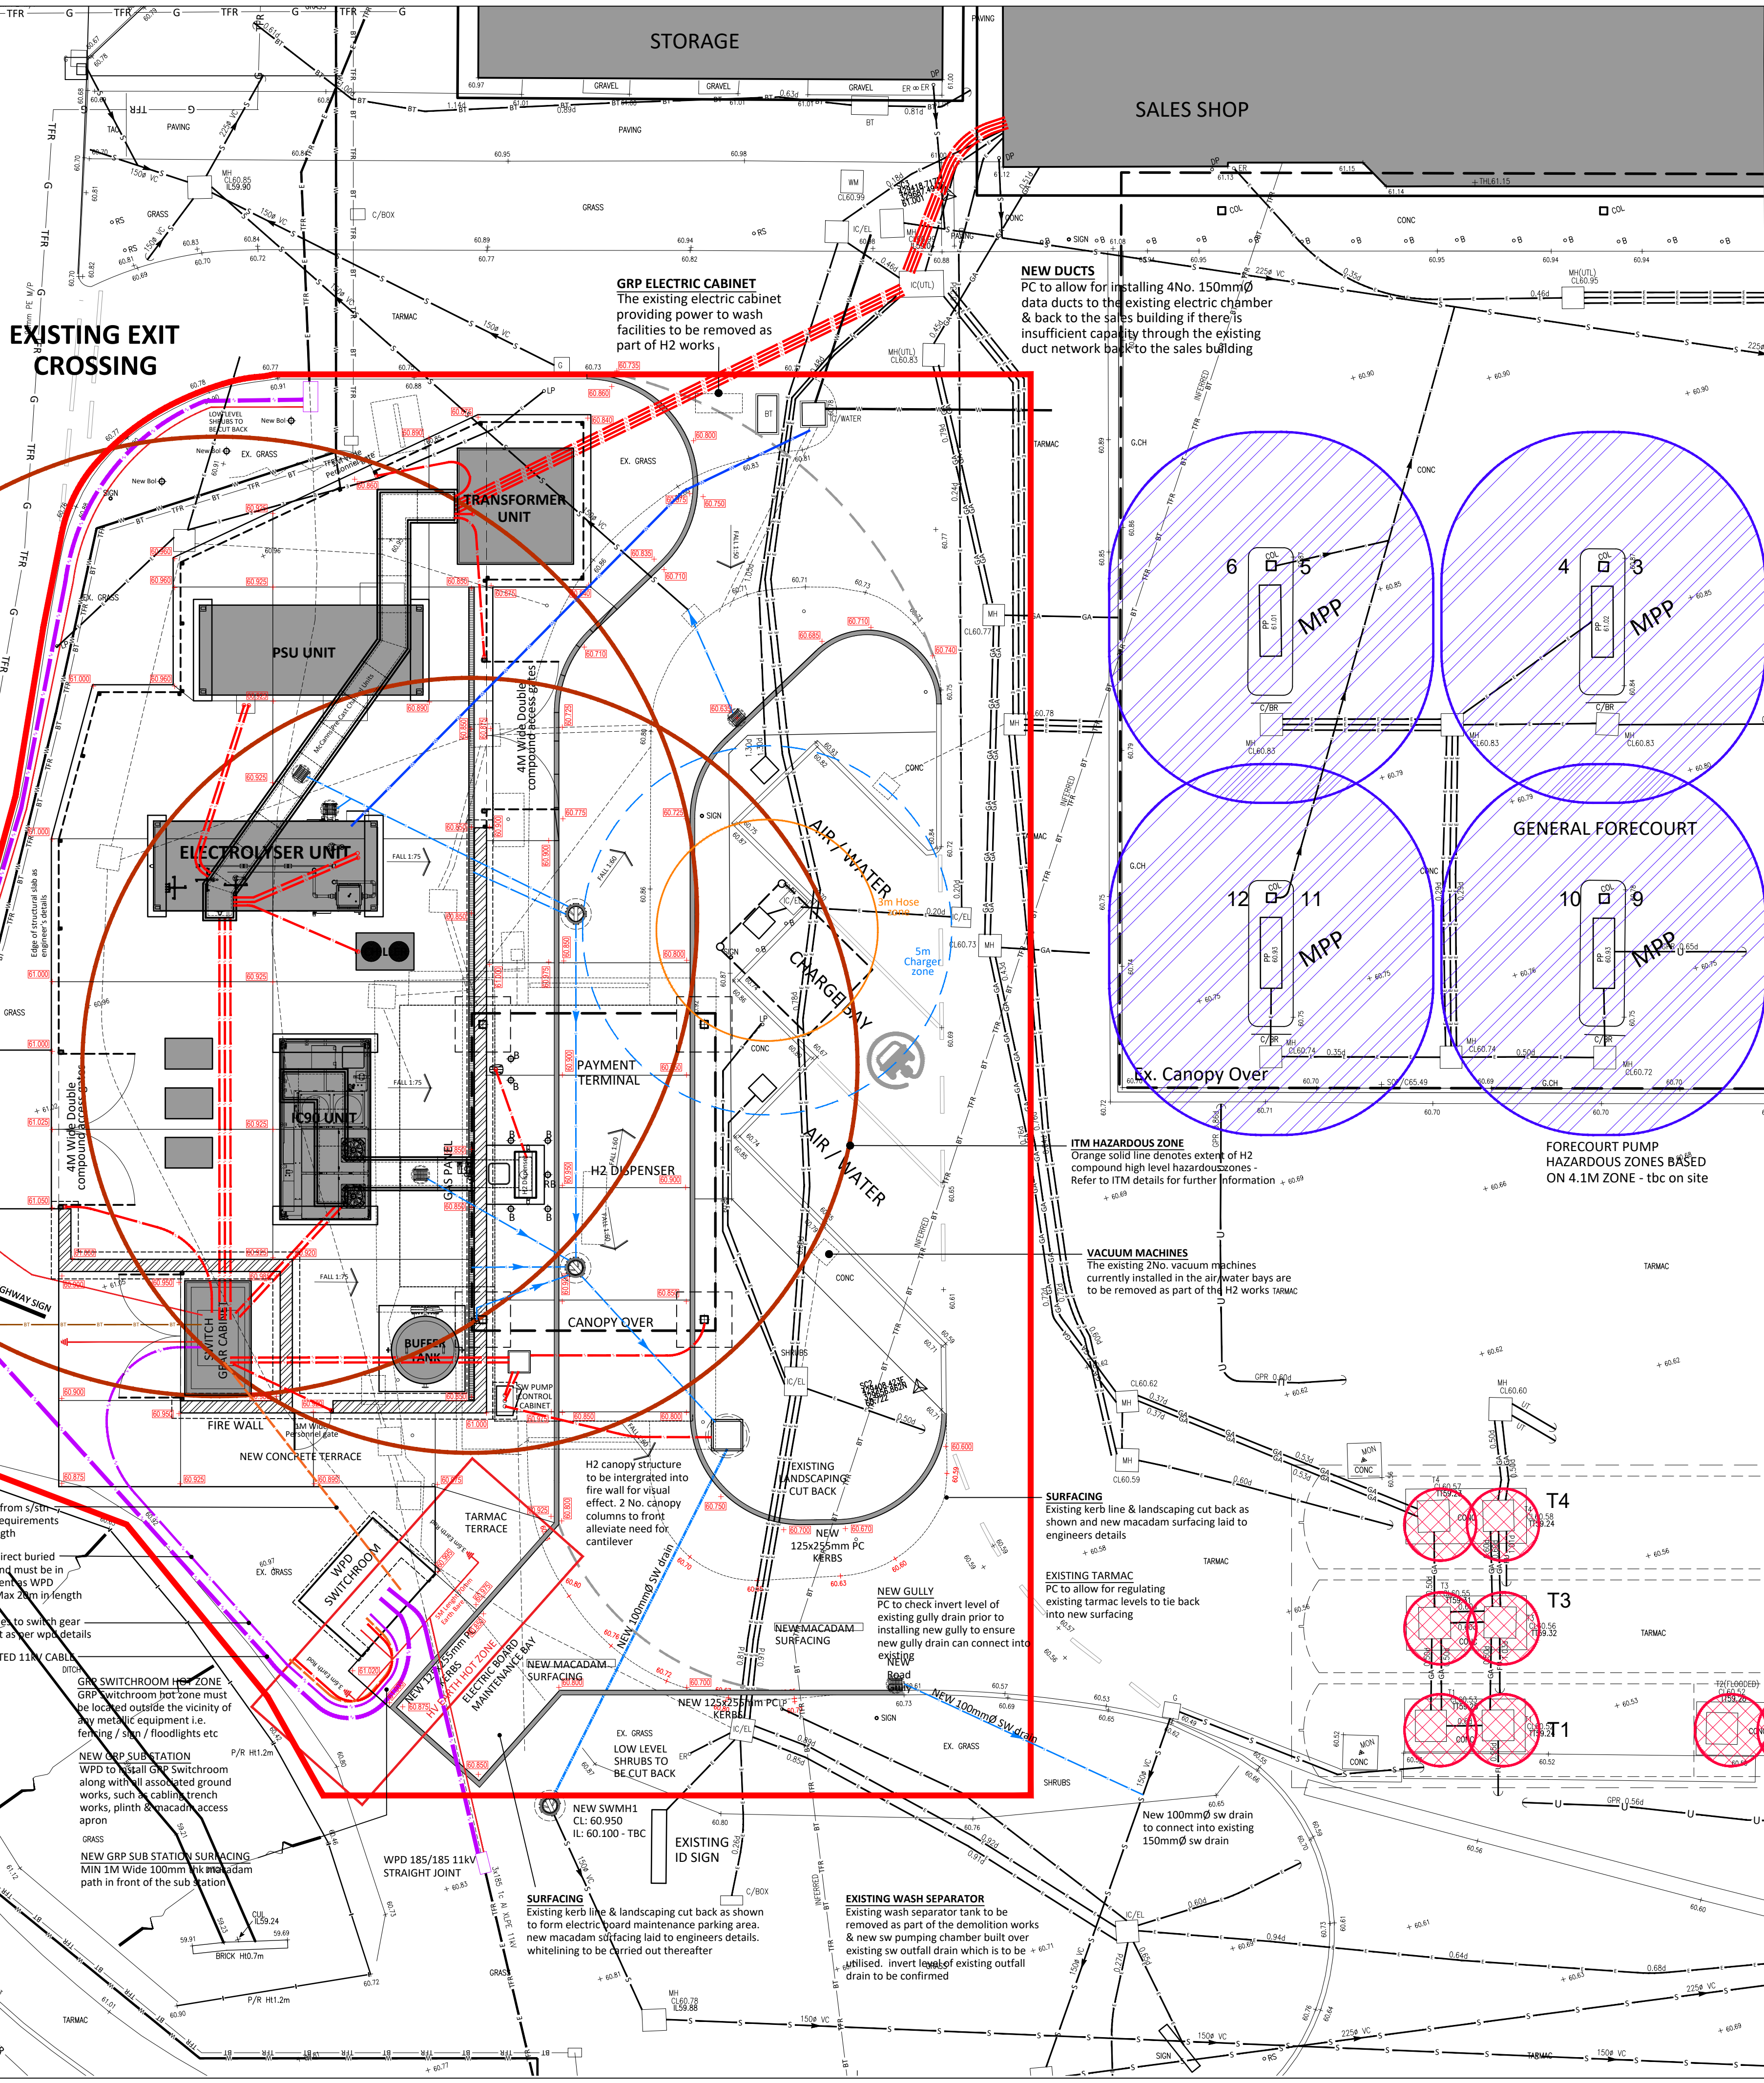

 
GENERAL NOTES

- THIS DRAWING HAS BEEN PREPARED FOR CONSTRUCTION PURPOSES ONLY
- DO NOT SCALE OFF THIS DRAWING
- THIS DRAWING IS TO BE READ IN CONJUNCTION WITH THE FOLLOWING ALONG WITH ALL OTHER SPECIALIST DRAWINGS:

1. ITM details and specifications
2. Structural Engineers details and specifications
3. Malcolm Hughes Land Surveyors Topo and Underground Services drawing no. 52408/UG1 - September 2018
4. Jennings Design Details:

 
DERBY 10957168 - EXT-G-10 2021 - Existing Site Plan
 DERBY 10957168 - GSP-11 2021 - General Site Plan
 DERBY 10957168 - CBP-12 2021 - Compound Base Plan
 DERBY 10957168 - CSP-13 2021 - Compound Services Plan
 DERBY 10957168 - CED-14 2021 - Compound Elevations & Details
 DERBY 10957168 - SOP-15-1 2021 - Setting Out Plan (Sheet 1)
 DERBY 10957168 - SOP-15-2 2021 - Setting Out Plan (Sheet 2)
 DERBY 10957168 - TROC-16 2021 - Track Layout
 DERBY 10957168 - CL17 2021 - Canopy Layout

EXISTING UNDERGROUND SERVICES KEY

	British telecom
	Sewer surface water
	Electric cables
	Fuel line
	Fuel gauge line
	Gas pipes
	Water pipes
	Unidentified GPR or electro location trace
	Electric HV cables
	End of trace

AR	Assumed Route	GPR	Ground Penetrating Radar
BD	Backdrop	TFR	Taken From Records
c	Cable Riser	PE	Polyethylene Pipe
d	Depth	UTS	Unable To Survey
PR	Pipe Riser	UR	Unable To Rod
OF	Offset Fill	UT	Unable To Trace
T	Tank	NVP	No Visible Pipes
VR	Vapour Recovery Point		
UTL	Unable To Lift		

NOTE:
THIS DRAWING HAS BEEN PREPARED BASED OFF MALCOLM HUGHES LAND SURVEYORS TOPO AND UNDERGROUND SERVICES DRAWING NO. 52408/UG1 - SEPTEMBER 2018 & EVC RECORD DRAWINGS DWG NO. 10957168-AB Rev A Record - 2018, ALONG WITH TOUREEN AS INSTALLED SERVICE DIVERSION RECORDS (BT, GAS, WATER)



PROJECT: SHELL DERBY
ETWALL ROAD
DERBYSHIRE DE65 6DX

H2 - GENERAL SITE PLAN			
	SHELL UK LIMITED SHELL CENTRE LONDON SE1 7NA UNITED KINGDOM		
DRAWN BY :	VWW	SCALE :	1:100 @ A1
DATE :	23/07/2021	PLOT DATE :	23/07/2021
AD FILE :	E:\ARCHIVE\DRAWINGS\DERBY-10957168-CONST-21		
WG No :	10957168	GSP-11	21