


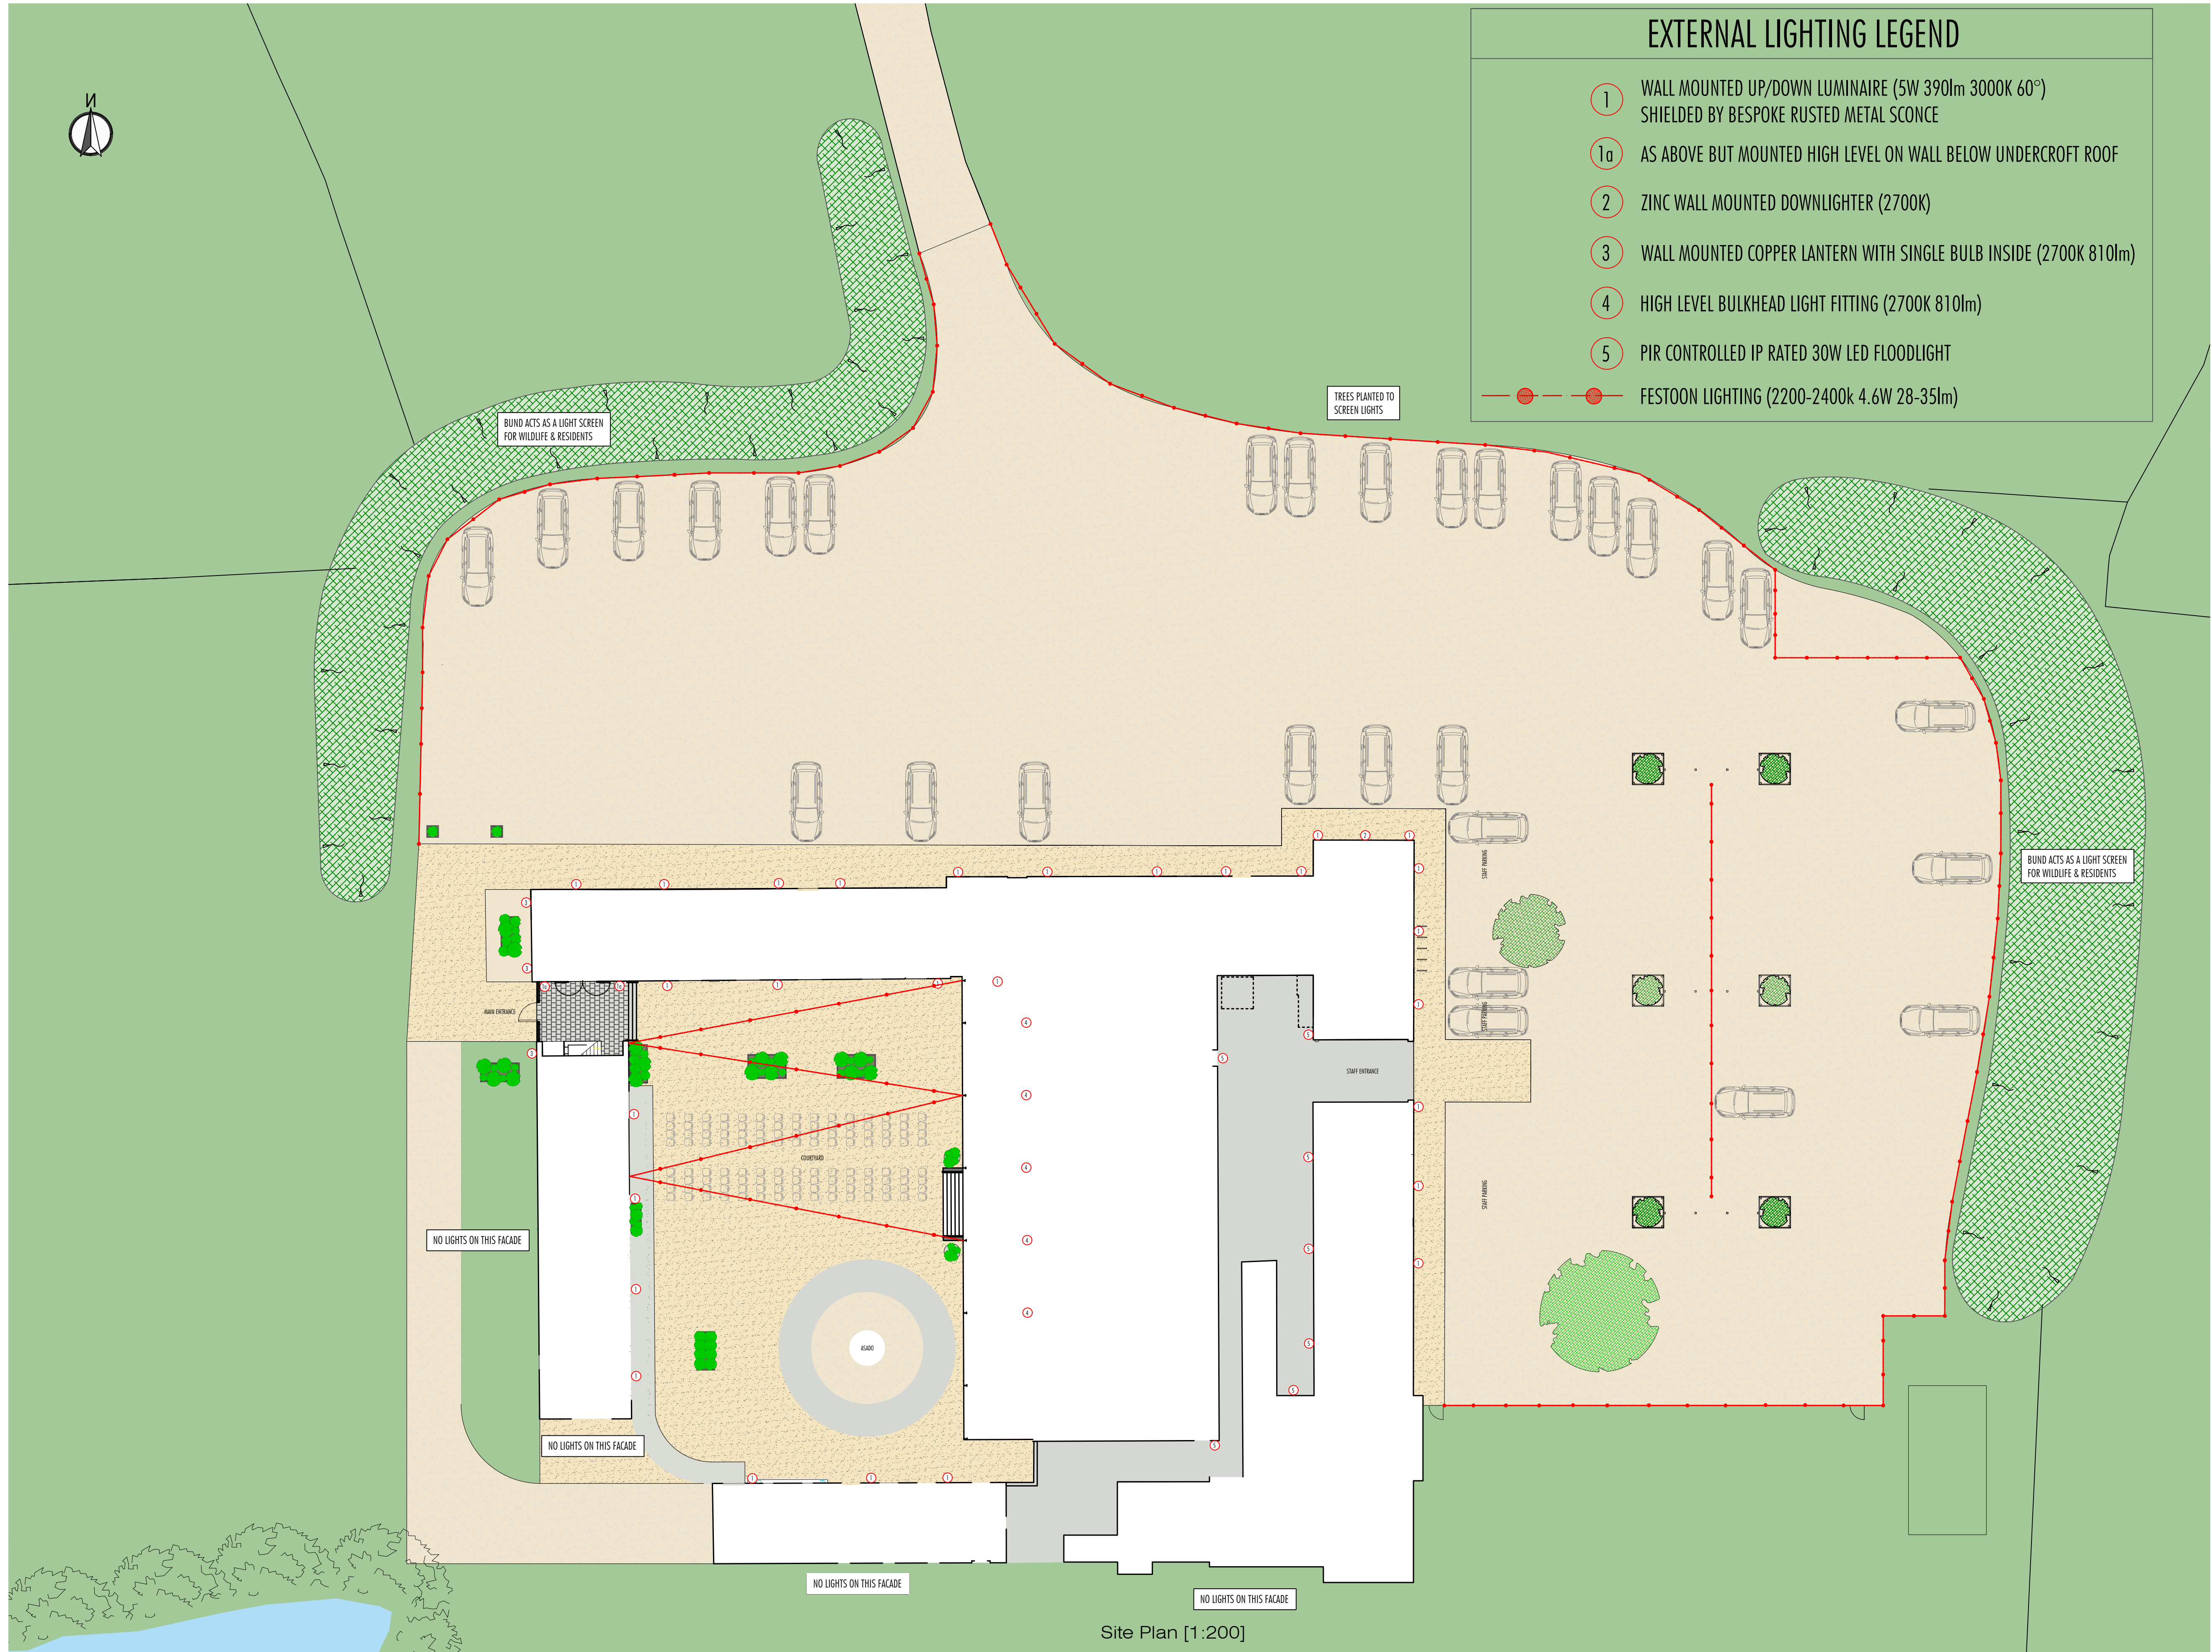

EXTERNAL LIGHTING LEGEND

- 1 WALL MOUNTED UP/DOWN LUMINAIRE (5W 390lm 3000K 60°)
SHIELDED BY BESPOKE RUSTED METAL SCONCE
- 1a AS ABOVE BUT MOUNTED HIGH LEVEL ON WALL BELOW UNDERCROFT ROOF
- 2 ZINC WALL MOUNTED DOWNLIGHTER (2700K)
- 3 WALL MOUNTED COPPER LANTERN WITH SINGLE BULB INSIDE (2700K 810lm)
- 4 HIGH LEVEL BULKHEAD LIGHT FITTING (2700K 810lm)
- 5 PIR CONTROLLED IP RATED 30W LED FLOODLIGHT
- FESTOON LIGHTING (2200-2400k 4.6W 28-35lm)

All dimensions are given for indicative purposes only.
All measurements should be checked on site prior to commencement and manufacturing.
If in doubt - ASK
This drawing remains the copyright property of Turner & Co Ltd and must not be reproduced without written consent

Rev	Date	Details	Drawn
C	16.12.21	Drawing pack collated for submission.	JH
Rev	Date	Details	Drawn
Client:	-----		
Project Title: Grangefields Farm, Dalbury Lees, Ashbourne, DE6 5BH			
Drawing Title: Proposed as Existing Site Plan (with lighting)			
PLANNING DRAWING			
TURNER & Co.			
Turner & Co Ltd : Architectural Design : 1st Flr : Charity House Duke Street : Tutbury : Burton upon Trent : DE13 9NE 01283 813368 : www.tcctd.net : enquiries@tcctd.net			
Scale: 1:200	Date: 16.12.21	Drawn: JH	Checked: RT
Reference: GF251121	Drawing Nr: P010	Revision: C	

Site Plan [1:200]

These drawings should be read in tandem with the original planning drawings [REF: GF061016] and Discharge of conditions drawings [GF150519] for the purpose of regularisation.

Paper Size: A1